

PROJECT
STONE SEWER REPLACEMENT AND NEW DAVIS BROOK REGULATOR STRUCTURE

CLIENT
 City of Bangor, Maine
 73 HARLOW STREET
 BANGOR, ME 04401
 (207) 240-3700

CONSULTANT
 AECOM TECHNICAL SERVICES, INC.
 TWO CITY CENTER, SUITE 200
 PORTLAND, ME 04101
 PHONE: (207)775-2800
 www.aecom.com

CONSULTANTS

REGISTRATION



ISSUE/REVISION

NO.	DATE	DESCRIPTION
-	12-14-2018	ISSUED FOR BID
-	11-09-2018	FOR AGENCY REVIEW
1/R		

PROJECT NUMBER

60585566

Designed By:	J. SKELLY
Drawn By:	M. CURRAN
Dept Check:	C. BENZIGER
Proj Check:	K. MIGNONE
Date:	DECEMBER 2018
Scale:	AS NOTED

DISCIPLINE


CIVIL

SHEET TITLE


SITE PIPING PLAN

SHEET NUMBER

00 C-103

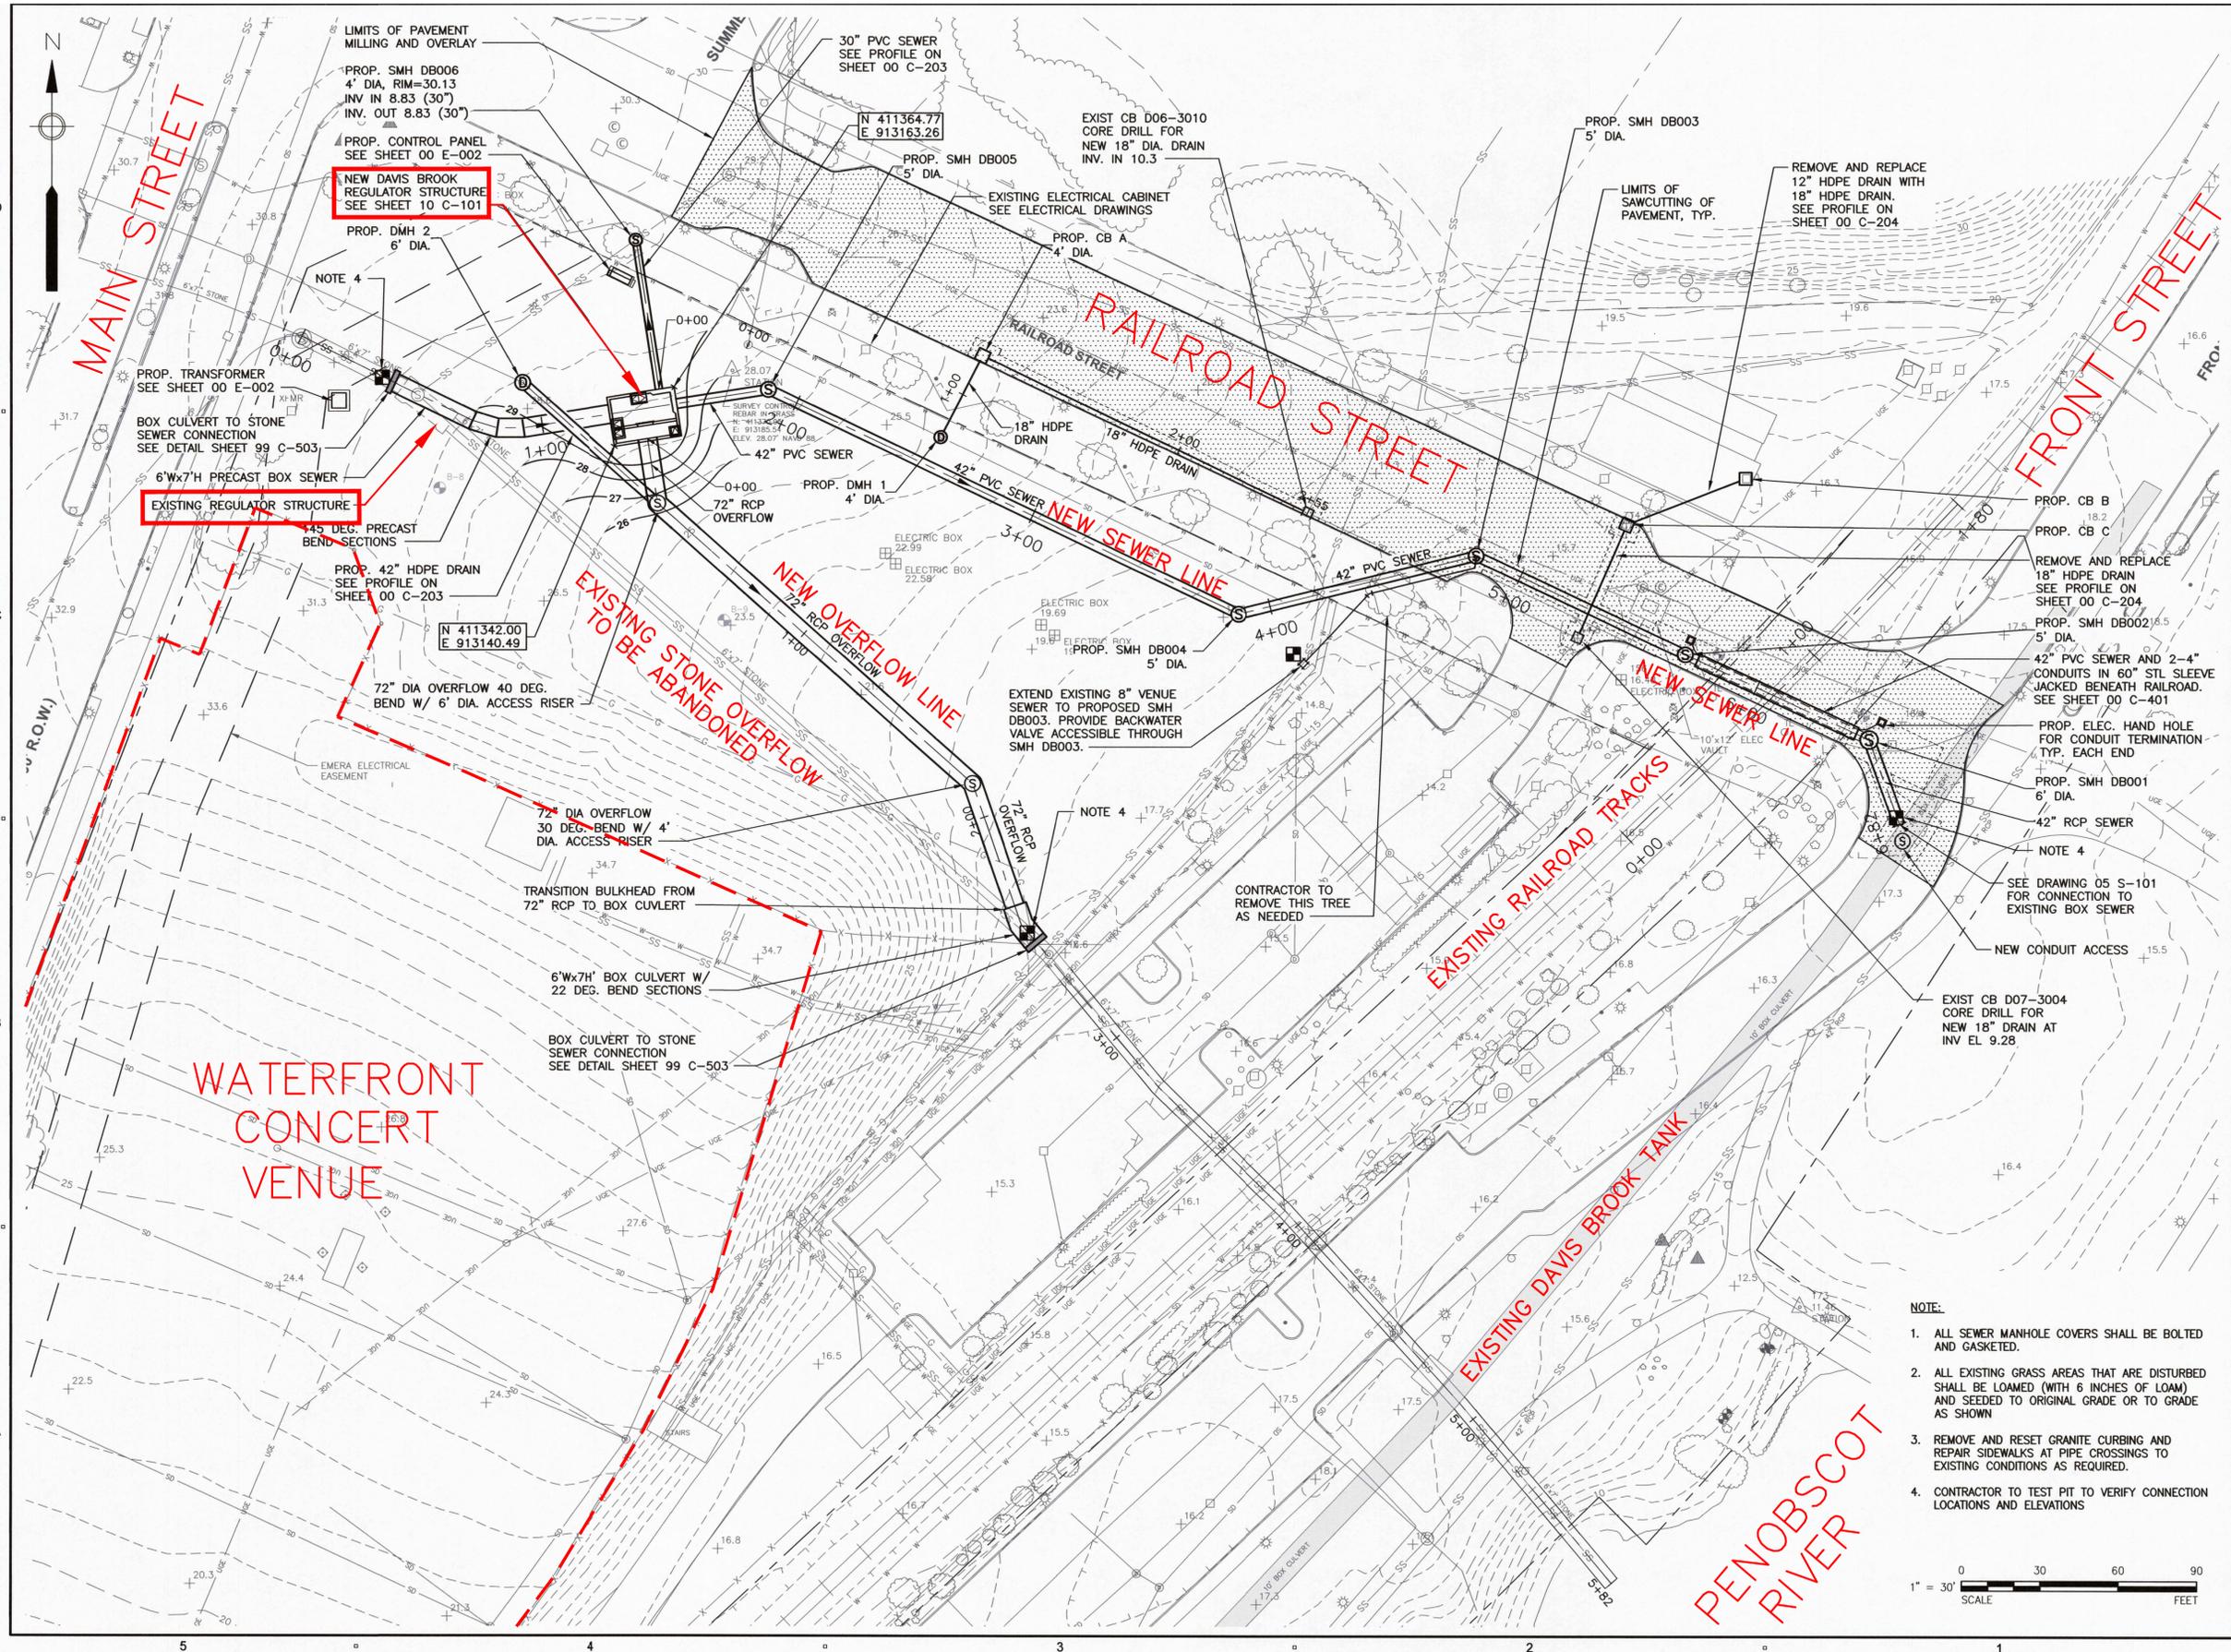

 - NOTE:**
1. ALL SEWER MANHOLE COVERS SHALL BE BOLTED AND GASKETED.
 2. ALL EXISTING GRASS AREAS THAT ARE DISTURBED SHALL BE LOAMED (WITH 6 INCHES OF LOAM) AND SEED TO ORIGINAL GRADE OR TO GRADE AS SHOWN
 3. REMOVE AND RESET GRANITE CURBING AND REPAIR SIDEWALKS AT PIPE CROSSINGS TO EXISTING CONDITIONS AS REQUIRED.
 4. CONTRACTOR TO TEST PIT TO VERIFY CONNECTION LOCATIONS AND ELEVATIONS



PATH: \\FLENAME\F\60585566 - BANGOR CS\CIVIL\SITE\UP-001.DWG
 LAST UPDATE: Thursday, December 13, 2018 2:43:38 PM
 PLOT DATE: Thursday, December 13, 2018 2:44:38 PM